


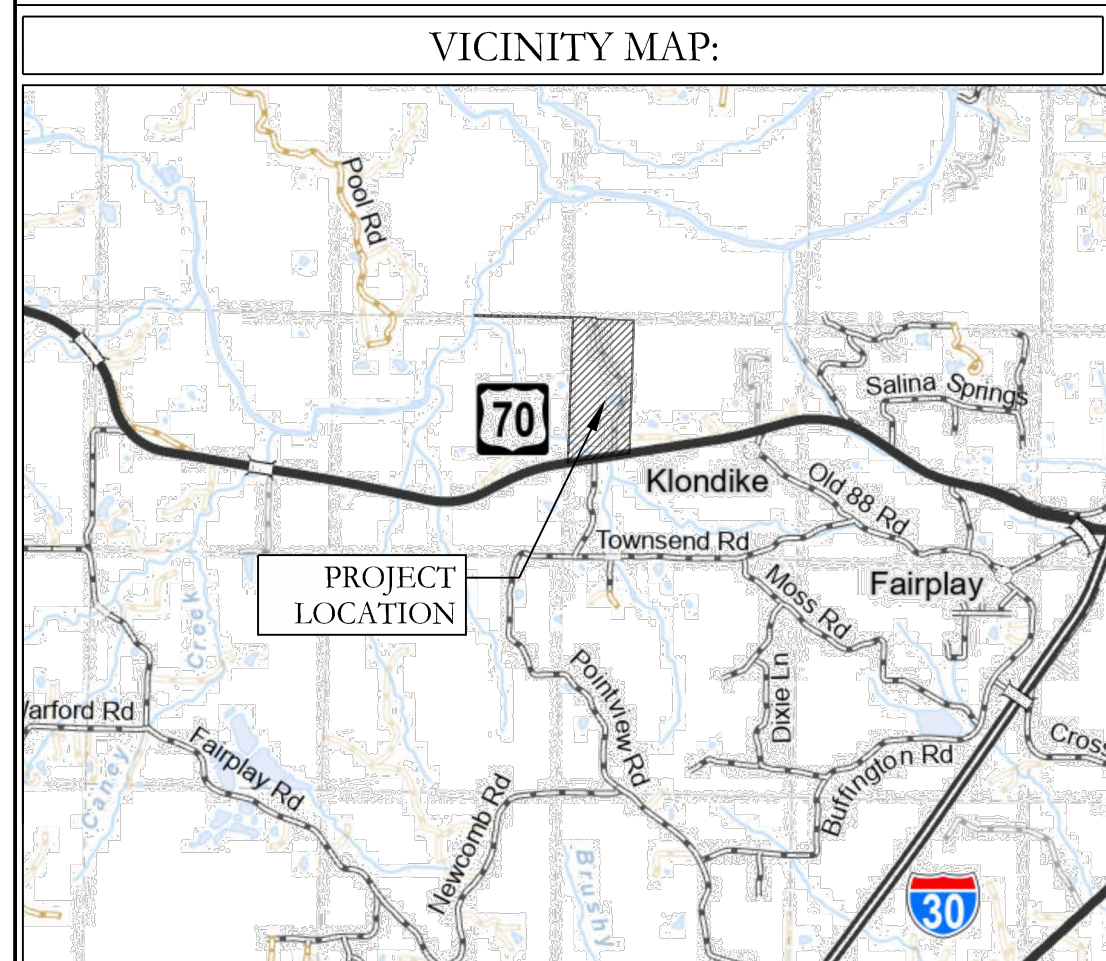

- | WATER CONSTRUCTION NOTES: | |
|---------------------------|---|
| 1. | ALL WATER CONSTRUCTION SHALL BE DONE IN ACCORDANCE WITH SALINE COUNTY UTILITIES' MASTER SPECIFICATIONS FOR DESIGN AND CONSTRUCTION OF WATER AND SEWER UTILITIES' LONG-SEIDE WATER SERVICE LINES SHALL BE ENCASED, INCLUDING THE LINES BENEATH THE C&D-DE-SAC. |
| 2. | ALL SERVICE CROSSINGS SHALL BE 1" DRUGO SERVICE LINE ENCASED IN A 2" PVC SLEEVE. |
| 3. | ALL WATER MAIN FITTINGS SHALL BE METAL GASKET MECHANICAL JOINT FITTINGS |

- HOPE**
CONSULTING
ENGINEERS - SURVEYORS
- 70 North College Ave,
Fayetteville, Arkansas 72701
Suit 11C
PH. (501)315-2626
FAX (501) 315-0024
www.hopeconsulting.com

FOR USE AND BENEFIT OF:
SUMMIT PROPERTIES, LLC

UTILITY PLAN
PRIVATE SCHOOL
HIGHWAY 70
SALINE COUNTY, ARKANSAS

DATE: 09-15-2026		C.A.D. BY:			DRAWING NUMBER: 23-0364		
REVISED:		CHECKED BY:					
SHEET: C4.00		SCALE: 1"=200'					
500	01S	14W	0	34	310	62	1664